
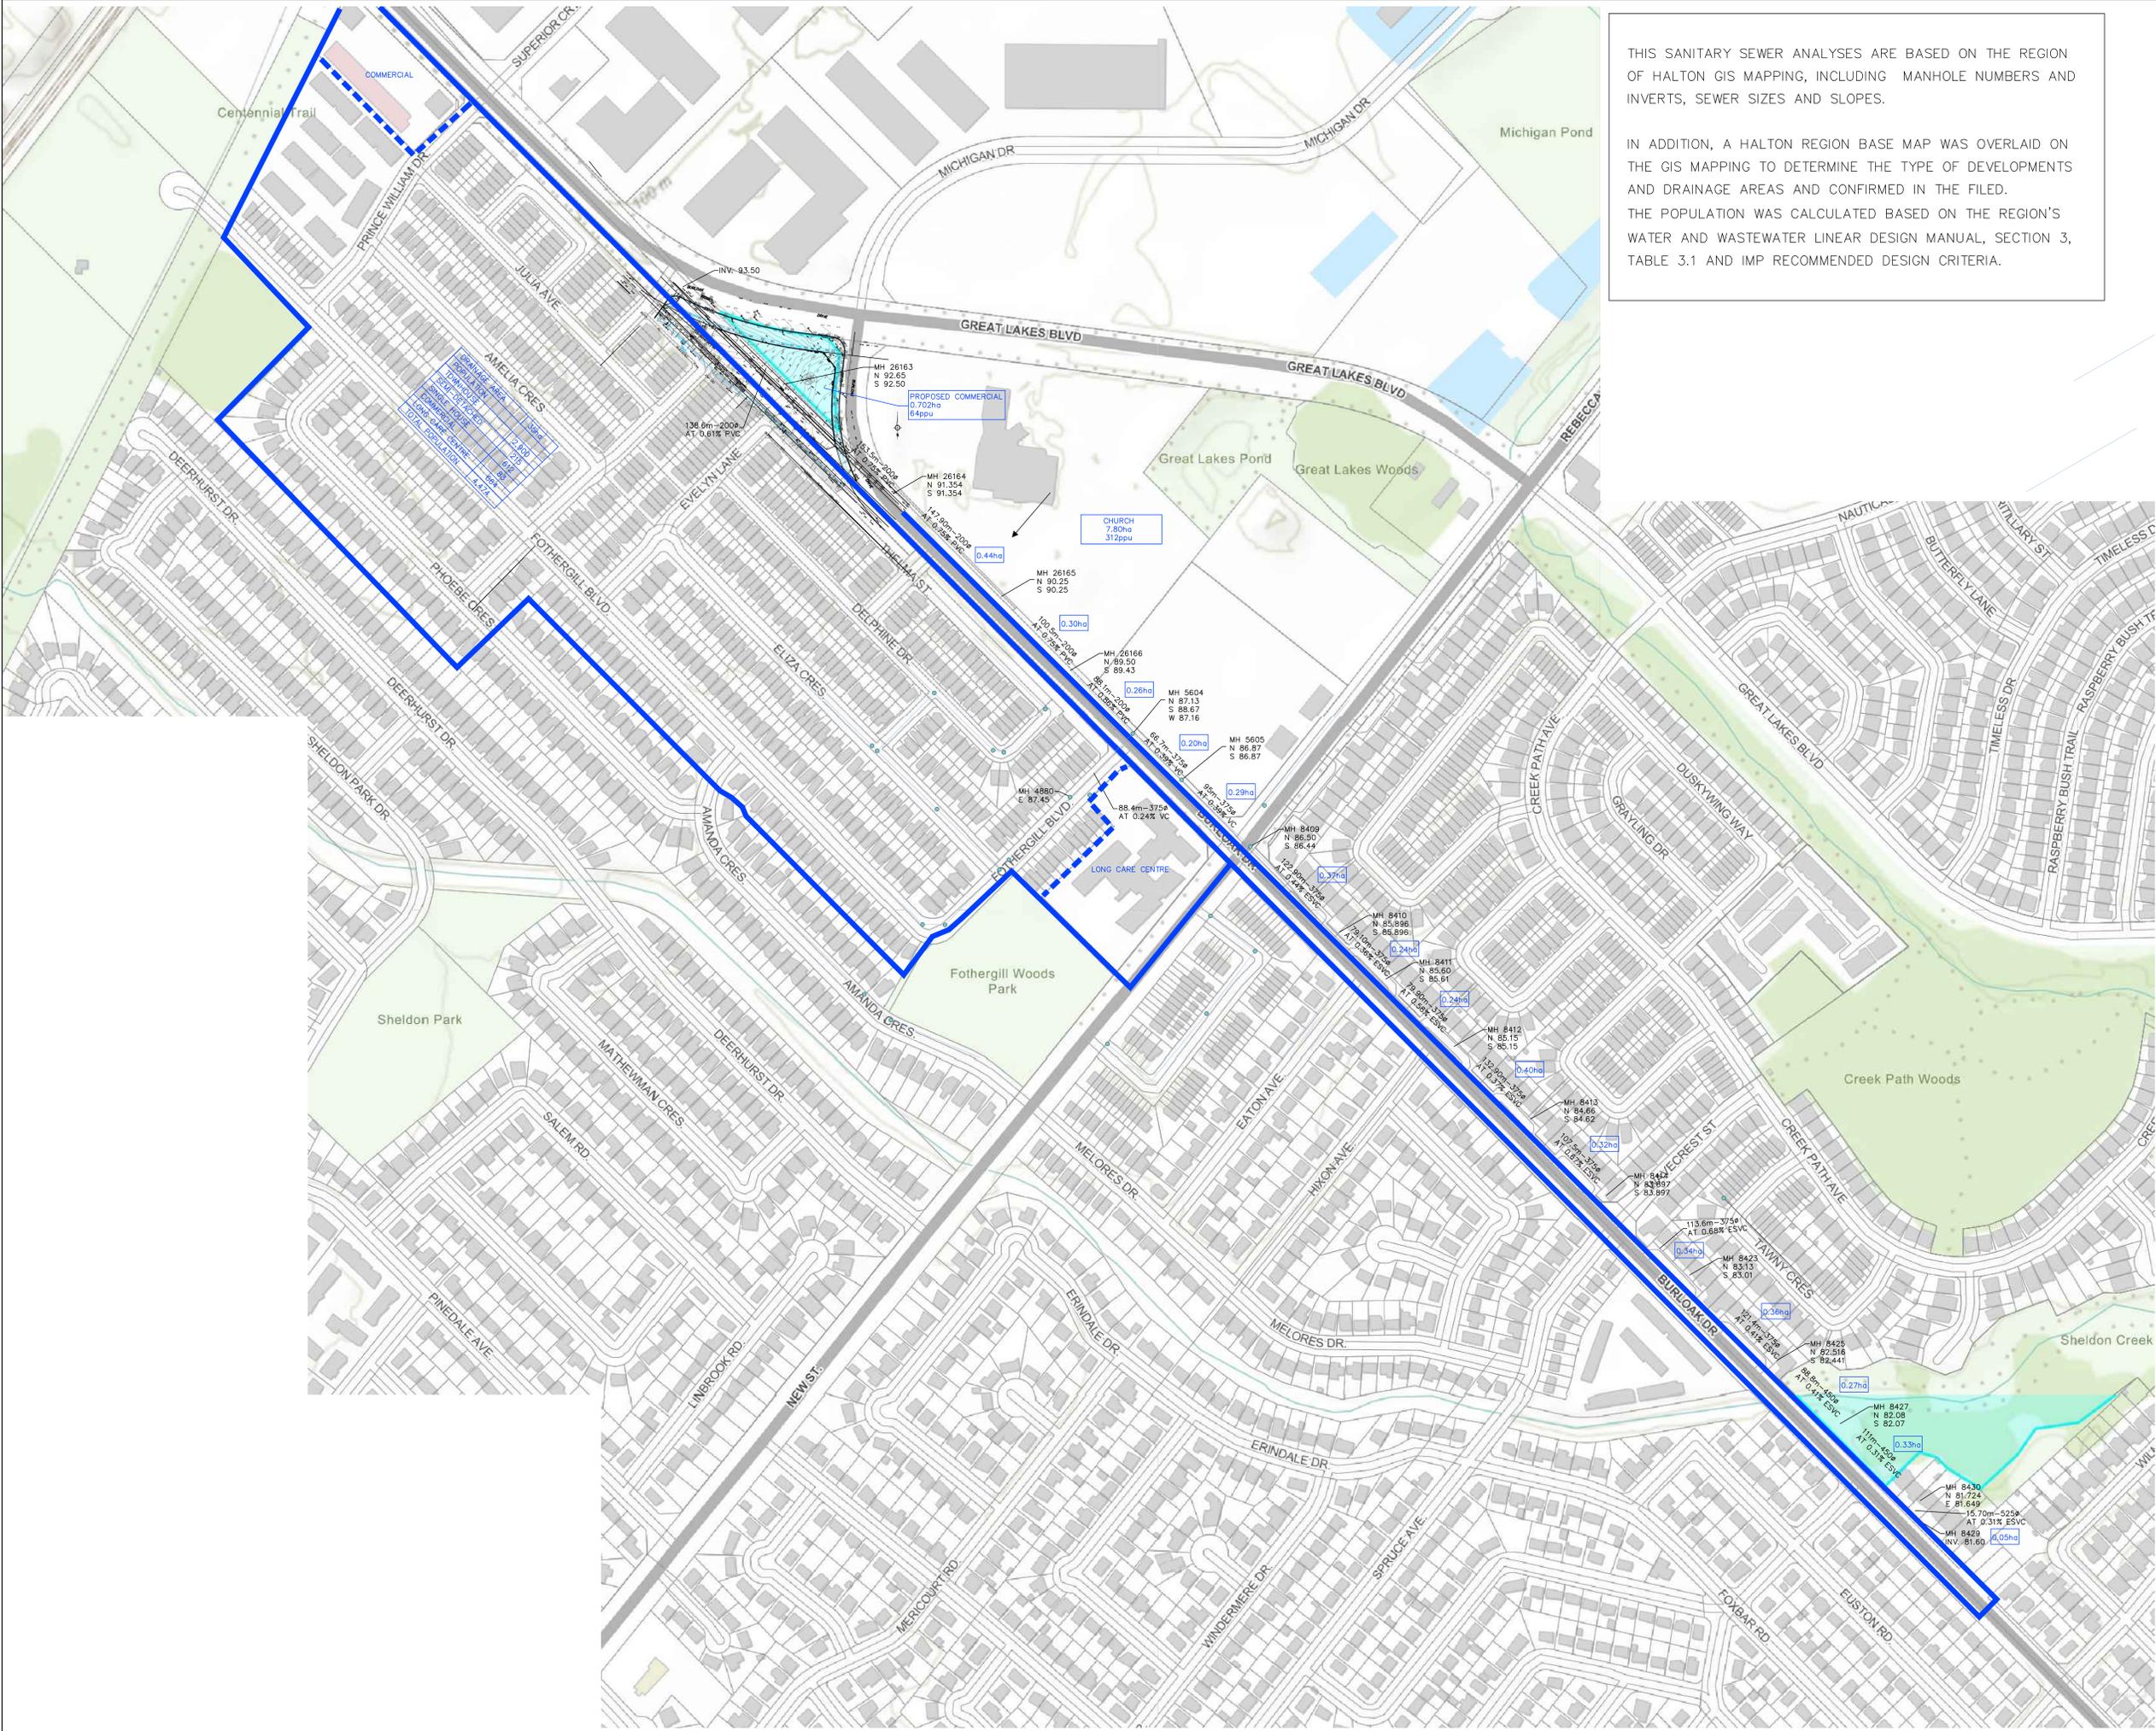


THIS SANITARY SEWER ANALYSES ARE BASED ON THE REGION OF HALTON GIS MAPPING, INCLUDING MANHOLE NUMBERS AND INVERTS, SEWER SIZES AND SLOPES.

IN ADDITION, A HALTON REGION BASE MAP WAS OVERLAID ON THE GIS MAPPING TO DETERMINE THE TYPE OF DEVELOPMENTS AND DRAINAGE AREAS AND CONFIRMED IN THE FILED. THE POPULATION WAS CALCULATED BASED ON THE REGION'S WATER AND WASTEWATER LINEAR DESIGN MANUAL, SECTION 3, TABLE 3.1 AND IMP RECOMMENDED DESIGN CRITERIA.

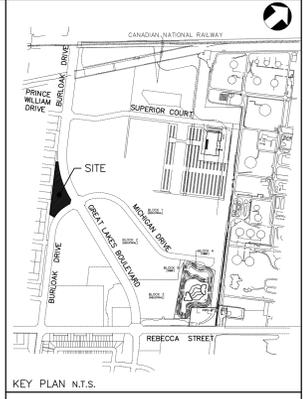

|  |                       |            |
|--|-----------------------|------------|
| 1.   | ISSUED FOR SUBMISSION | 2025.10.20 |
| Rev. #   | Details               | Date       |
| <b>Urbtech Engineering Inc.</b><br>1200 Spicers Road, Suite 8, Oakville, ON L6L 2X4<br>Telephone: 905 896 7364 |                       |            |
| <b>BURLOAK PLAZA</b><br>ABDULLAH AL EYADEH<br>580 BURLOAK DRIVE<br>TOWN OF OAKVILLE                            |                       |            |
| <b>SANITARY SEWER ANALYSIS</b>   |                       |            |
| SCALE 2000   | PROJECT No. 24-484    | PLAN No.   |
| DRAWN BY G.J.  | SITE PLAN No.         | SA-1       |
| CHECKED BY A.J.  | XXXXXXXXXXXXXXXXXXXX  |            |